


# Power Plant

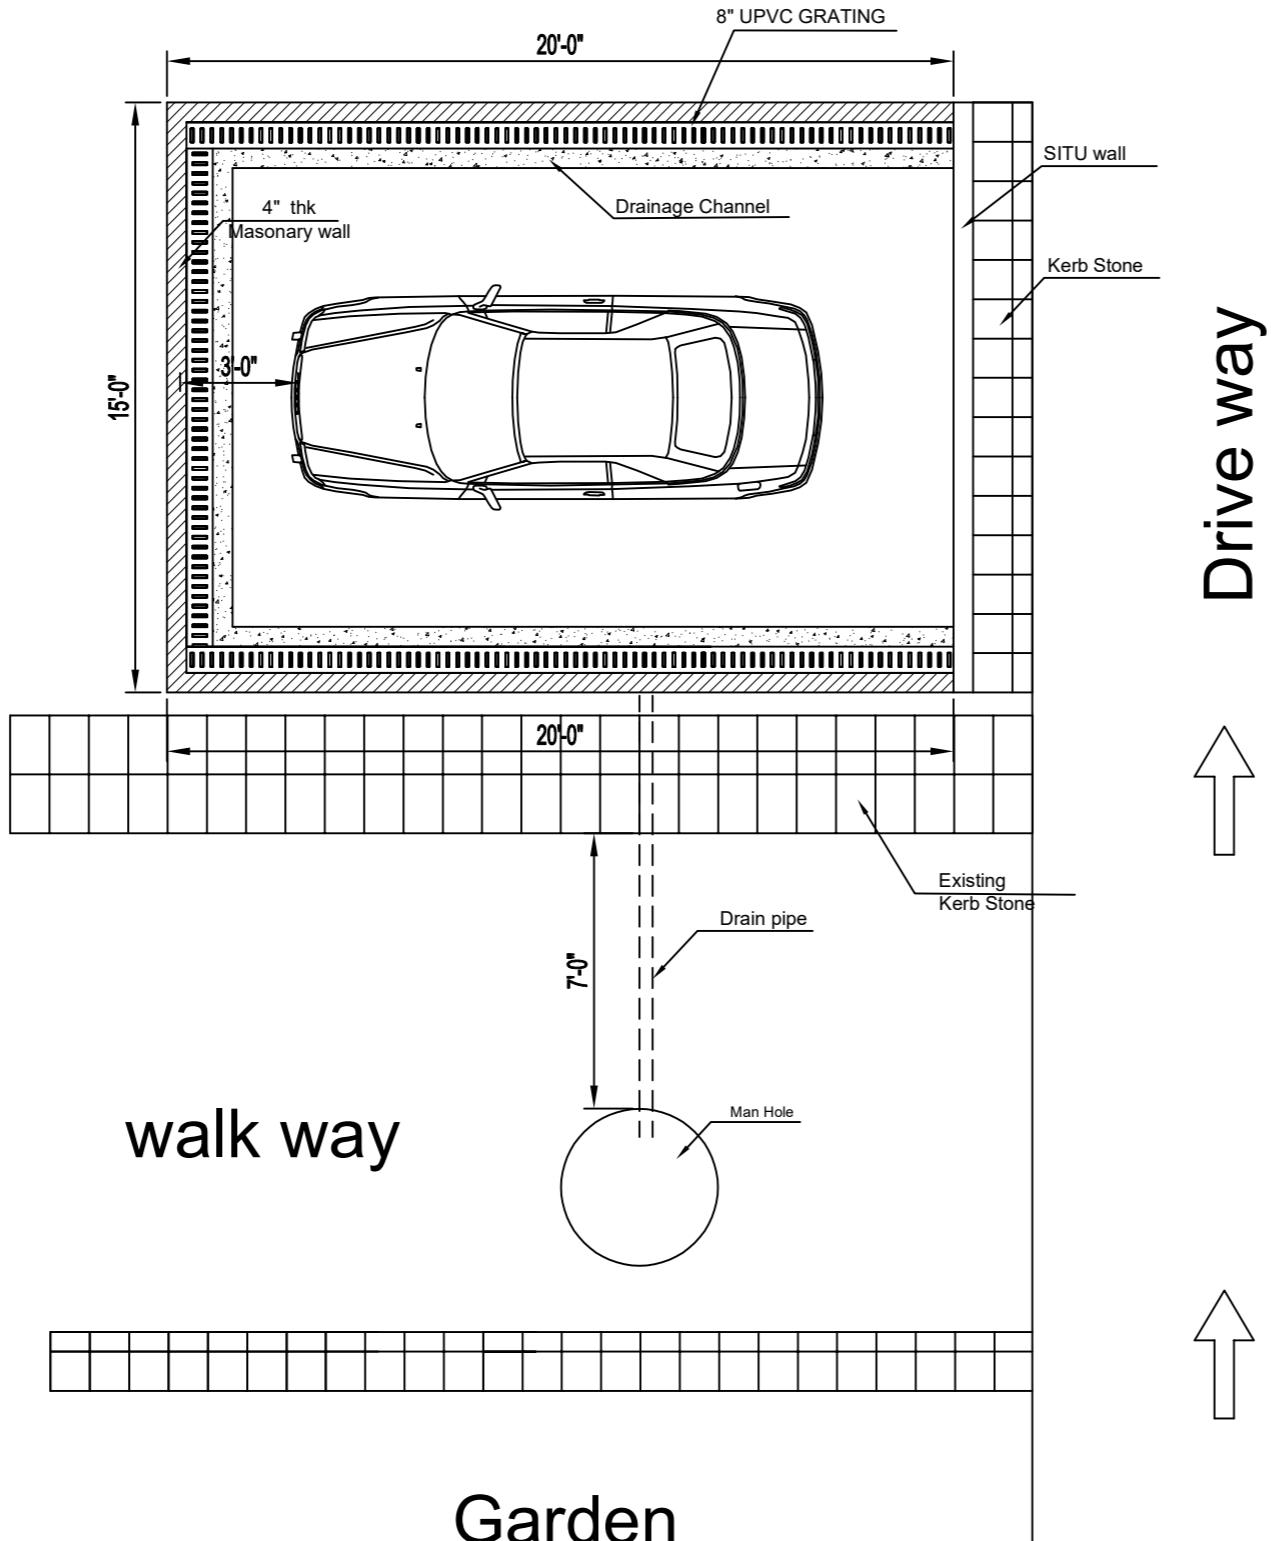

Stores and Offices  
Building

CLIENT:  
**IBA** Institute of  
Business Administration  
Karachi  
Leadership and Ideas for Tomorrow

PROJECT:  
**Vehicle Service Area**

PROJECT LOCATION:  
**IBA MAIN CAMPUS**

DRAWING NO:  
**IBA-VSA-01**

BY:


PROJECT NO: JOB # :

APPROVED BY: DATE:  
18-Dec-2025


P.ARCHITECT: SCALE:  
N.T.S.

ARCHITECT : SCALE:  
N.T.S.

DRAWN BY: CHECKED BY:  
SYED FARAZ

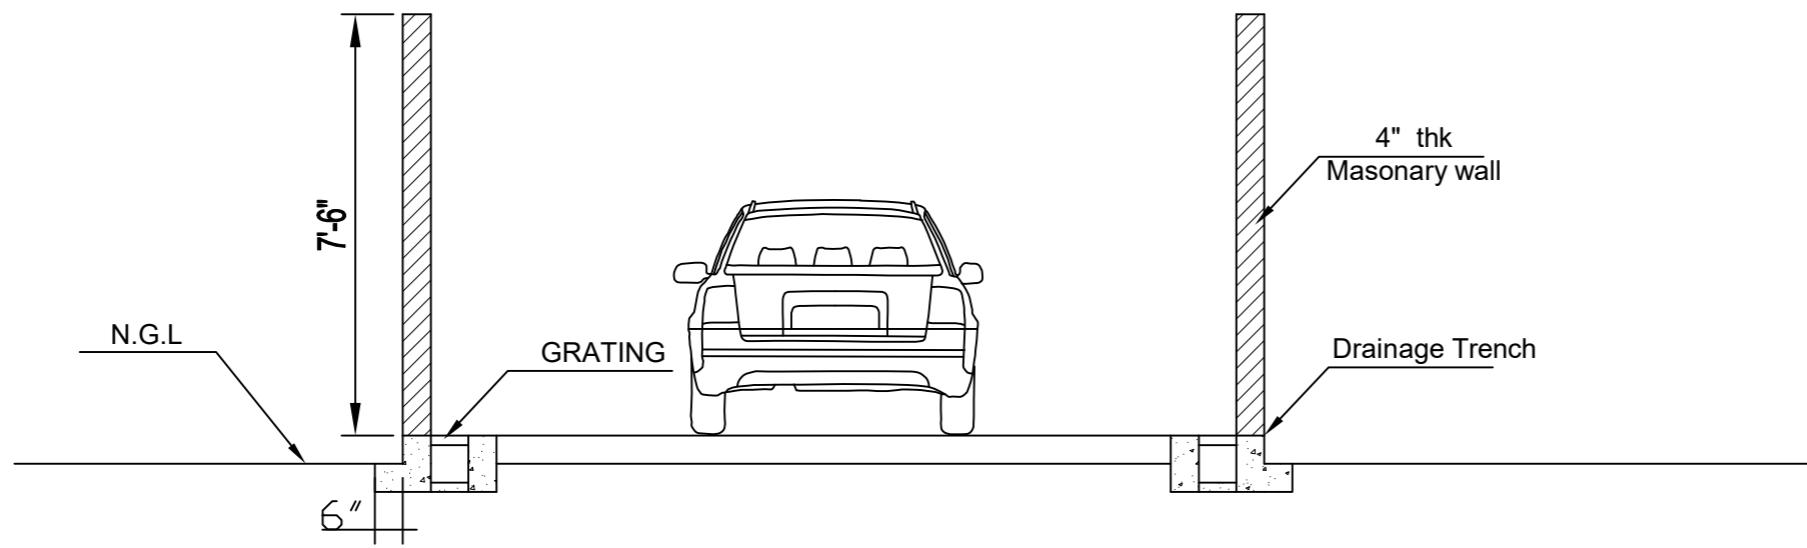

## Section A

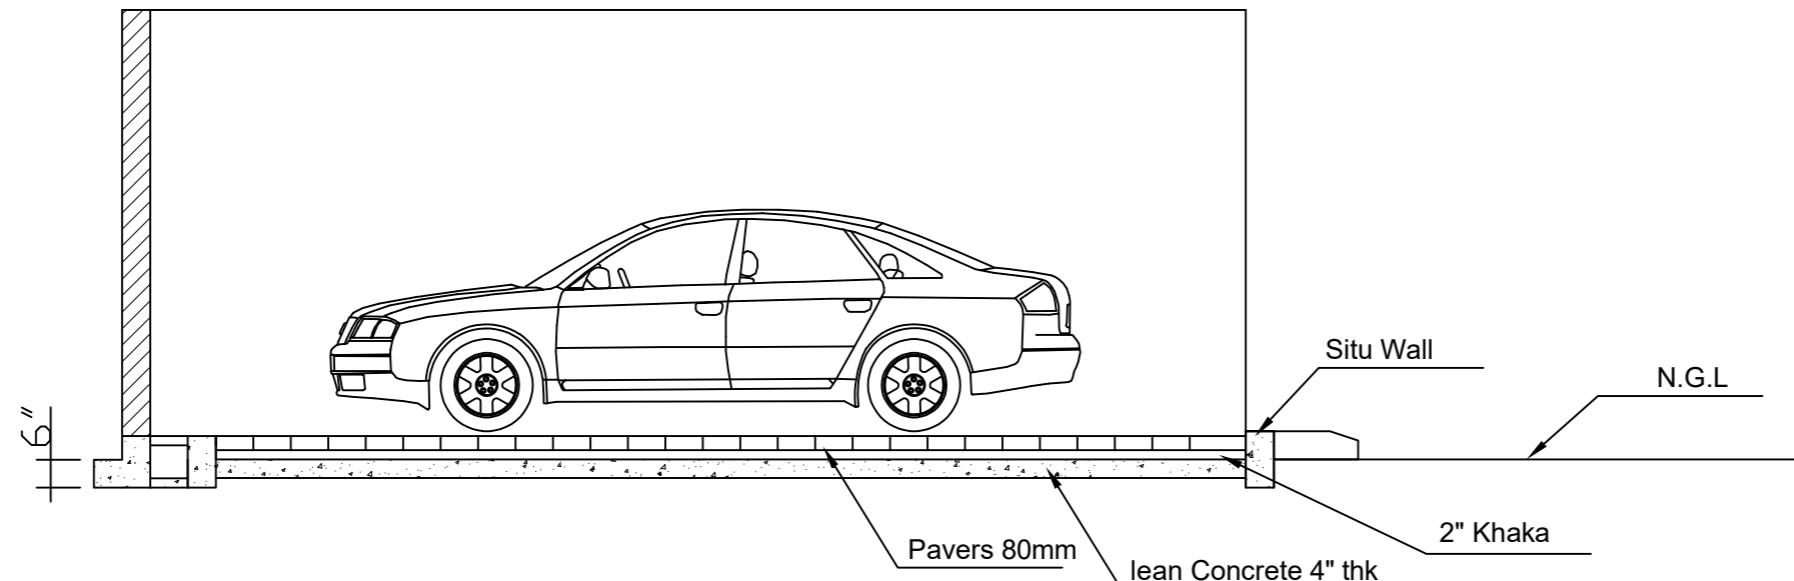

## Section B

CLIENT:  
**IBA** Institute of  
 Business Administration  
 Karachi  
 Leadership and Ideas for Tomorrow

PROJECT:  
**Vehicle Service Area**

PROJECT LOCATION:  
**IBA MAIN CAMPUS**

DRAWING NO:  
**IBA-VSA-01**

BY:

PROJECT NO: JOB # :

APPROVED BY: DATE:  
 18-Dec-2025

P.ARCHITECT: SCALE:  
 N.T.S.

ARCHITECT : SCALE:  
 N.T.S.

DRAWN BY: CHECKED BY:  
 SYED FARAZ